

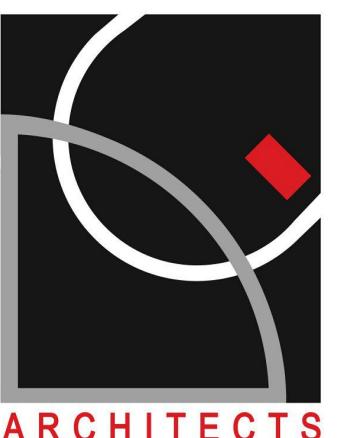


LIGHTING FIXTURE SCHEDULE						
MK	MANUFACTURER	PART NUMBER	LAMP	VA	MOUNTING	DESCRIPTION
SA2	MCGRAW EDISON	GLEON-SA2A-740-U-T2-VM-XX	9357 LUM LED	66	WALL	SITE FIXTURE (TYPE 4)
SA4	MCGRAW EDISON	GLEON-SA2A-740-U-T4W-VM-XX	9468 LUM LED	66	WALL	SITE FIXTURE (TYPE 2)
SB4	MCGRAW EDISON	GLEON-SA4D-740-U-T4W-VM-XX-MS/X-L40W	31080 LUM LED	258	WALL	SITE FIXTURE (TYPE 4)
SC	LUMIERE	303-W2-LEDB2-4000-UNV-T2-DIM10-BK	1137 LUM LED	16	WALL	EXTERIOR SCONCE

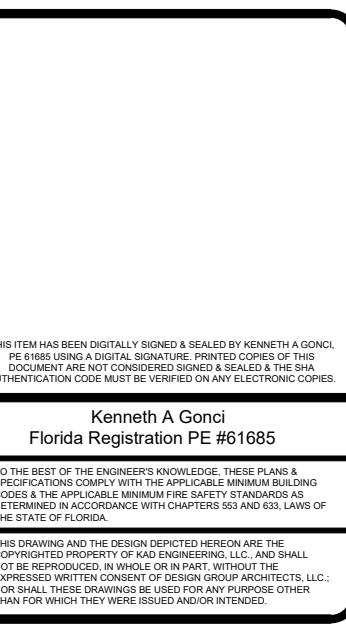

Rev	Description	11/15/2024
1	Building Department / Owner Revisions	01/30/2025
2	Fire Alarm System Removed	04/23/2025
3	Site Plan Revised	
4		
5		
6		
7		
8		
9		

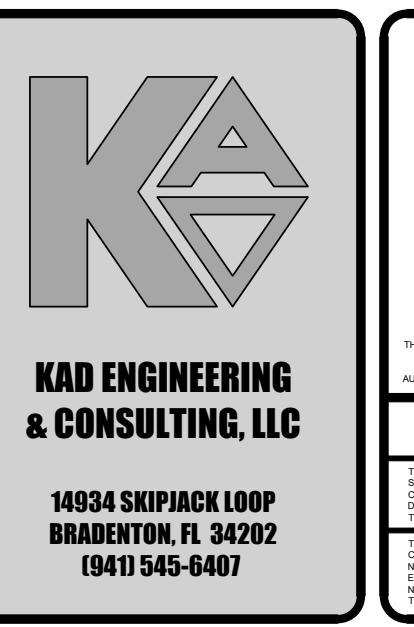

Project Name:
**A NEW HANGER FOR:
AGAPE FLIGHTS
100 AIRPORT AVE EAST
VENICE, FL 34285**



Drawn: JMM
Checked: KAG
Scale: 1"=20'
Date: 08/14/24
Sheet No:
E0.0